


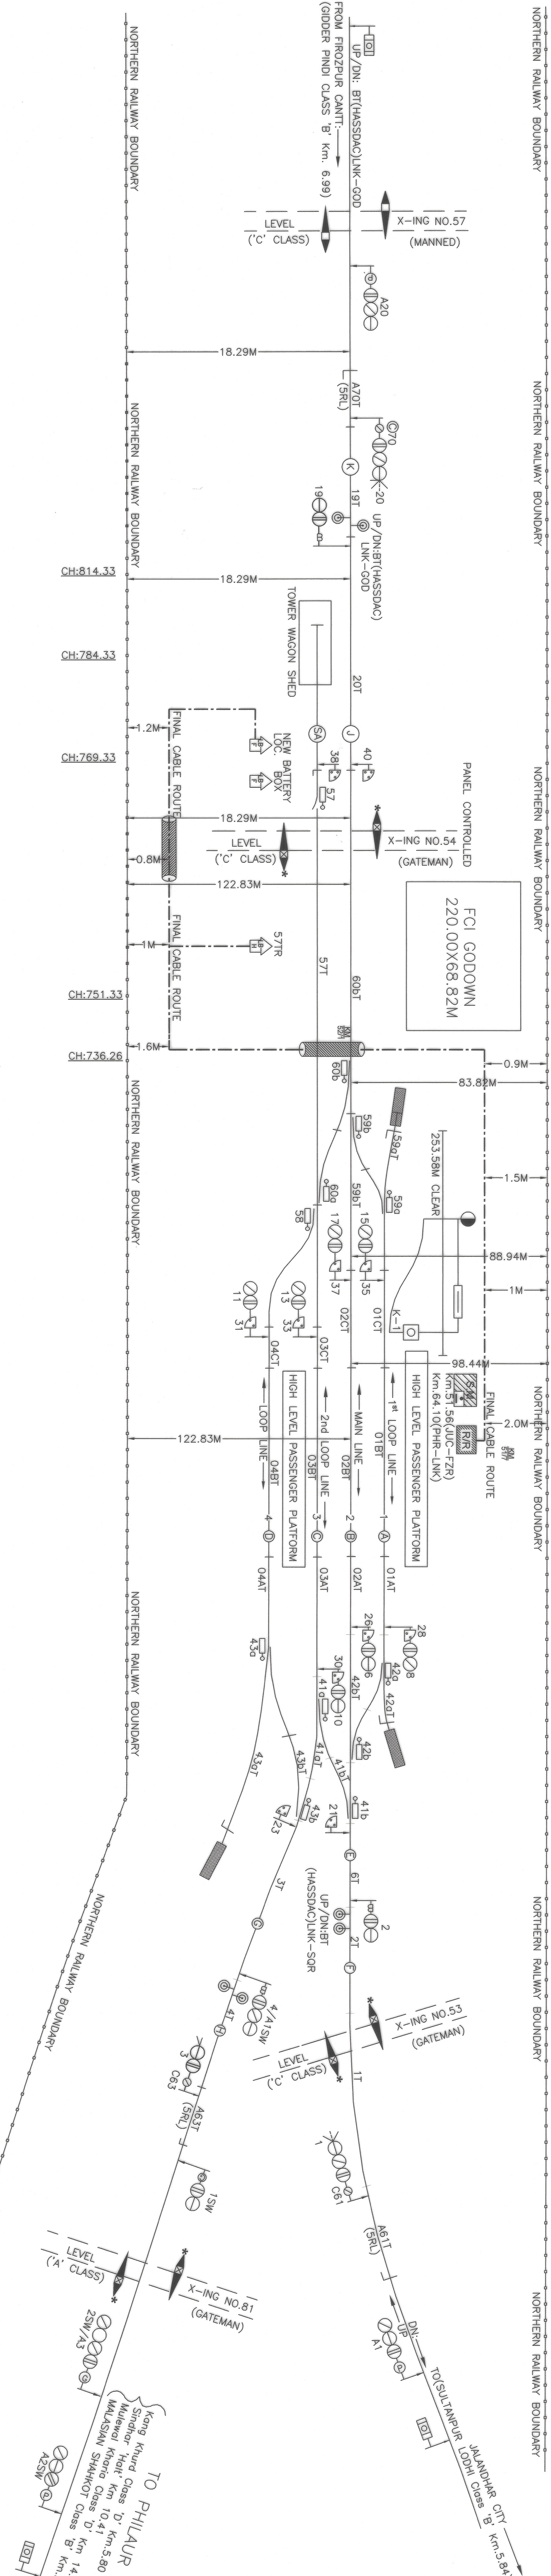

Completion Plan
Work Opened on dt:- **29.07.24**
Based on SIP No. 6954 ALT-'D'

COMPLETION PLAN

DDC REF. NO. PRC/GR NO.289/S&T/FZR/LNK/CRP	REV- 00, Date 15.05.2024
PROJECT NAME: B-5, Chhapra Ghat, Tower 3, 4th Floor, Sector 02, Noida (Uttar Pradesh) 201309, India	DESIGNER: S&T
DESIGN ENGINEER: S&T	DESIGN MANAGER: S&T

CHECKED	APPROVED	FINAL CABLE ROUTE PLAN FOR LOHIAN KHAS TOWER WAGON SHED	DRG. NO.
SSE/DRD/RE/UMB	SSE/SIG/RE/JUC	LOHIAN KHAS - FIROZPUR SECTION	DY.CSTE/RE/CRP/6954
TO SUIT SIP NO.6954 ALT-'D' COMP. ON:			NOT TO SCALE